


# PG&E REGIONAL SERVICE CENTER MERCED

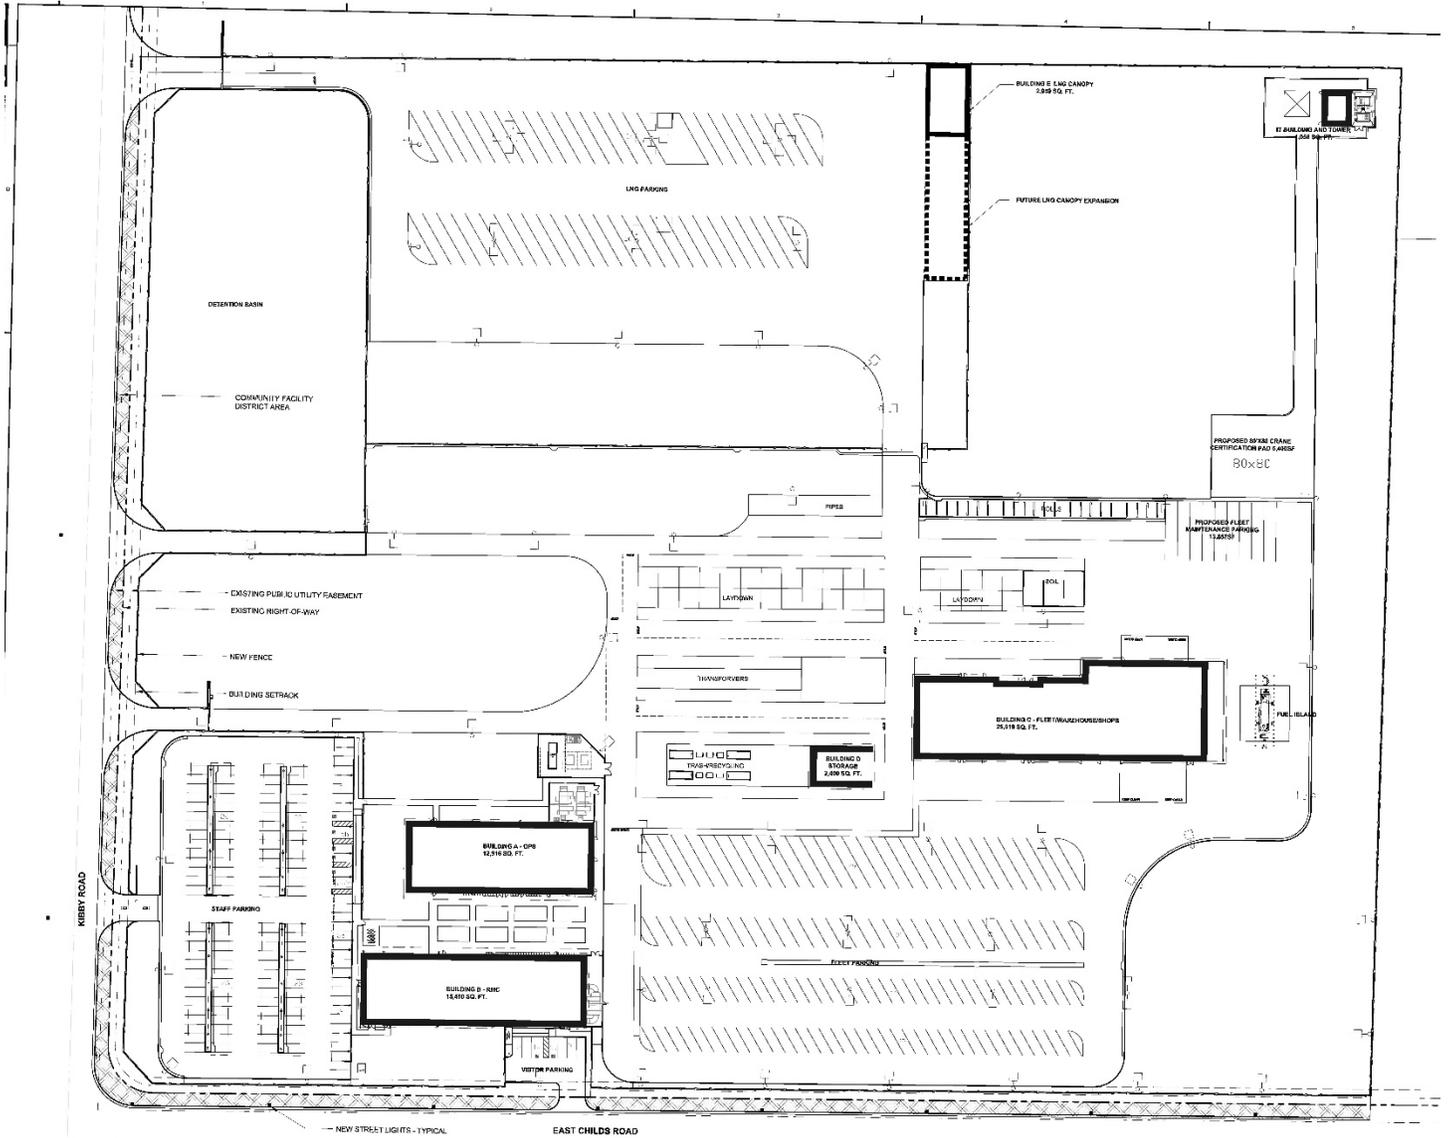

1 SITE PLAN - OVERALL  
SCALE: 1" = 40'

6

